

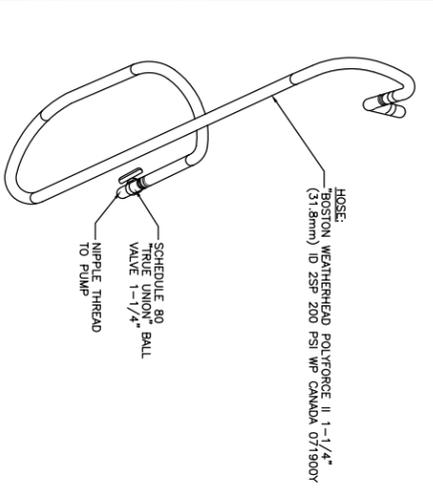



PLAN
NOT TO SCALE

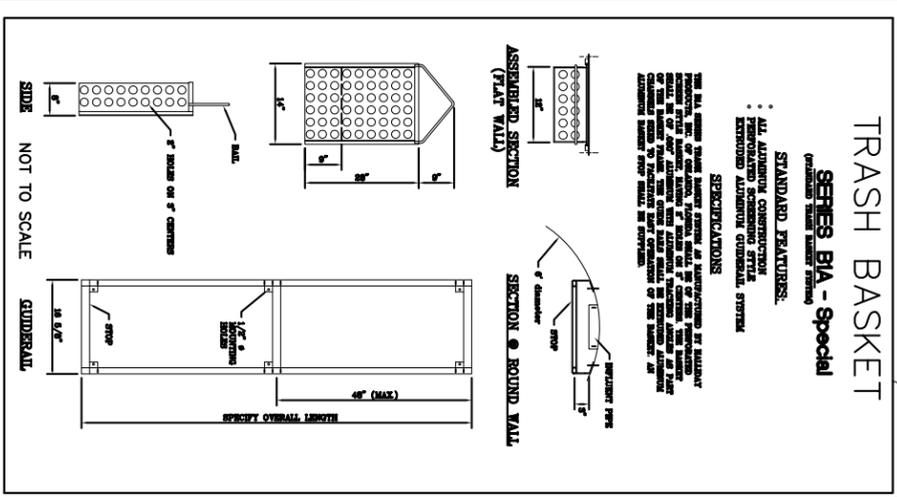

DISCHARGE HOSE DETAIL
NOT TO SCALE

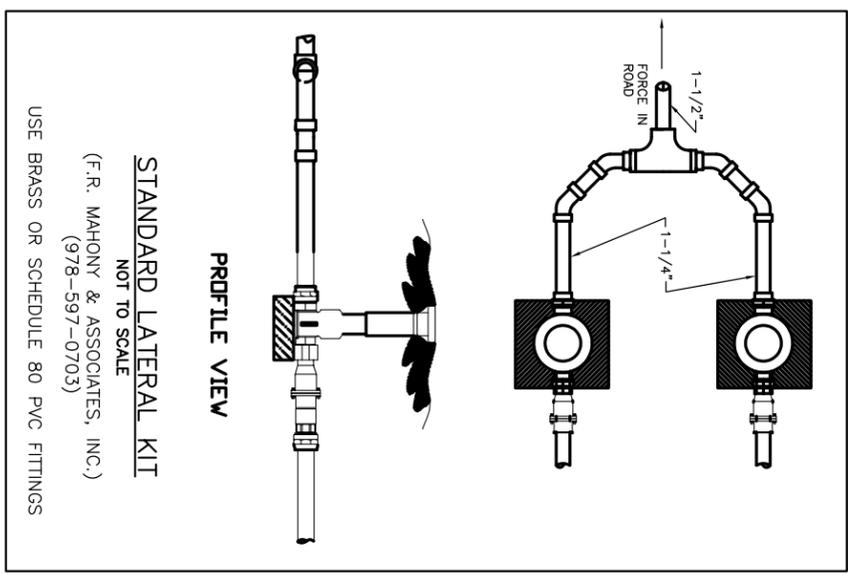

STANDARD LATERAL KIT
NOT TO SCALE
(F.R. MAHONY & ASSOCIATES, INC.)
(978-597-0703)
USE BRASS OR SCHEDULE 80 PVC FITTINGS

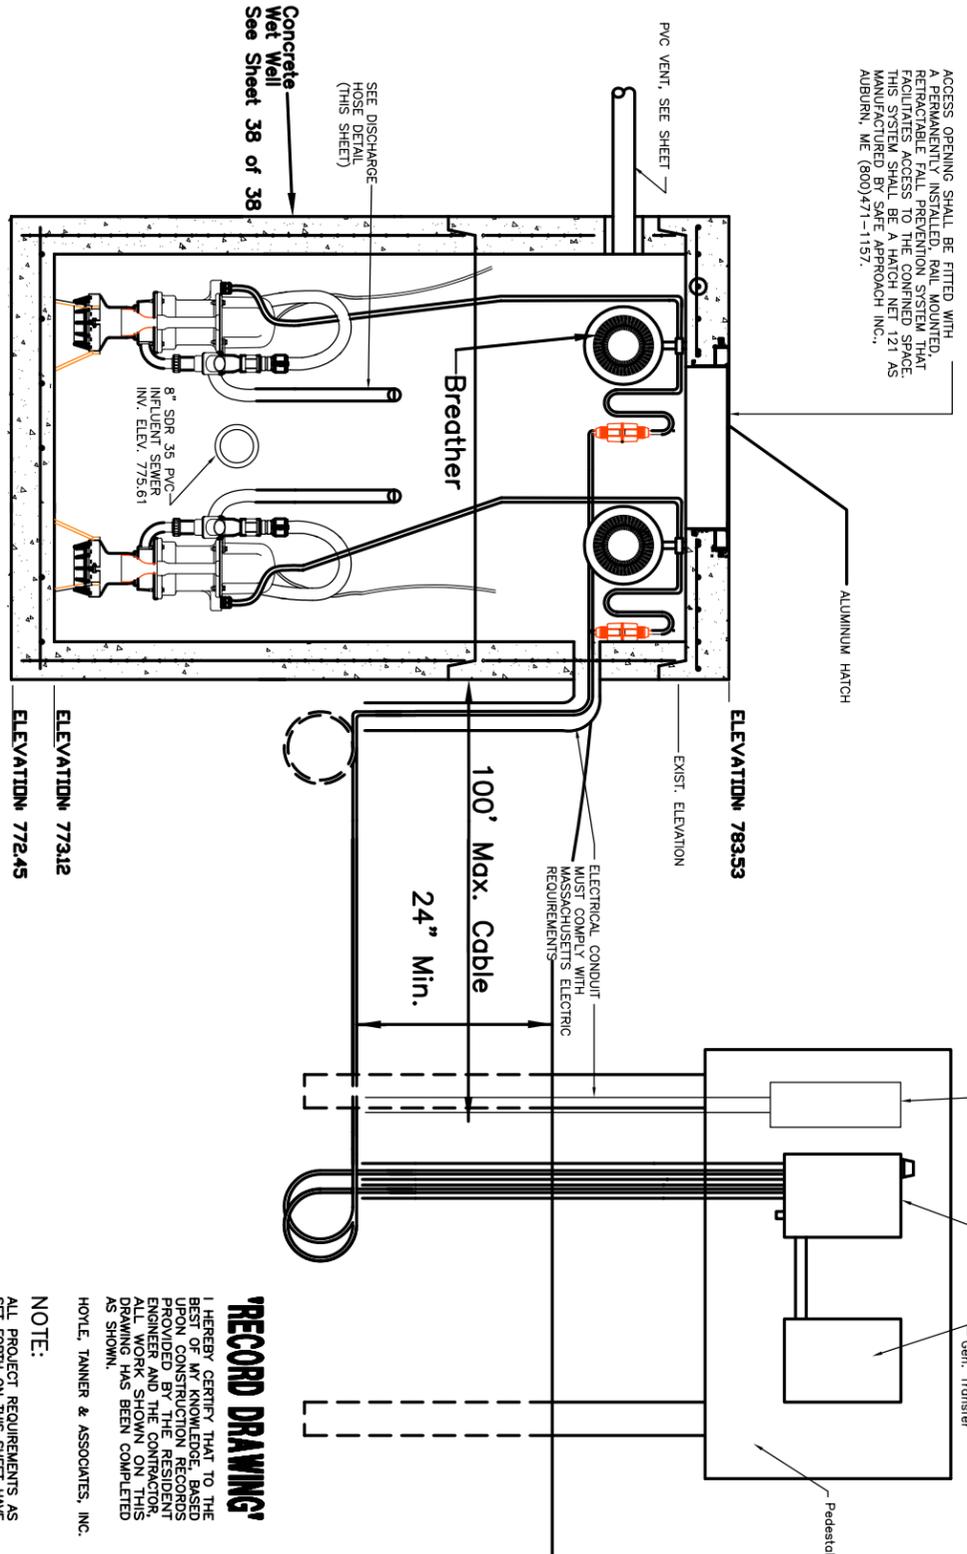

ELEVATION VIEW
NOT TO SCALE

PROJECT NO.	105709	FILE NAME	PL-PUMPSTA
1. RECORD DRAWING	C.B. W.C. W.C. 10/02	DR. BY	CHKD. BY
REV.	DESCRIPTION	APPRO. BY	DATE

HTA Hoyle, Tanner & Associates, Inc.
150 Dow Street • Manchester • New Hampshire 03101
Consulting Engineers

SCALE: AS SHOWN DATE: APRIL 2001 DES. BY JAH DR. BY CAB/RCP CHKD. BY NLT

CHERRY VALLEY SEWER DISTRICT
LEICESTER, MASSACHUSETTS
PLAN AND PROFILE
REDFIELD ROAD
PUMP STA. PLAN/DETAILS

RECORD DRAWING!
I HEREBY CERTIFY THAT TO THE BEST OF MY KNOWLEDGE AND BELIEF, THE INFORMATION CONTAINED HEREON IS TRUE AND CORRECT AND THAT I AM A LICENSED PROFESSIONAL ENGINEER IN THE STATE OF MASSACHUSETTS.
NOTE: ALL PROJECT REQUIREMENTS AS SET FORTH ON THIS SHEET HAVE BEEN COMPLETED AND THE WORK SHOWN ON THIS DRAWING HAS BEEN COMPLETED AS SHOWN.
HOYLE, TANNER & ASSOCIATES, INC.